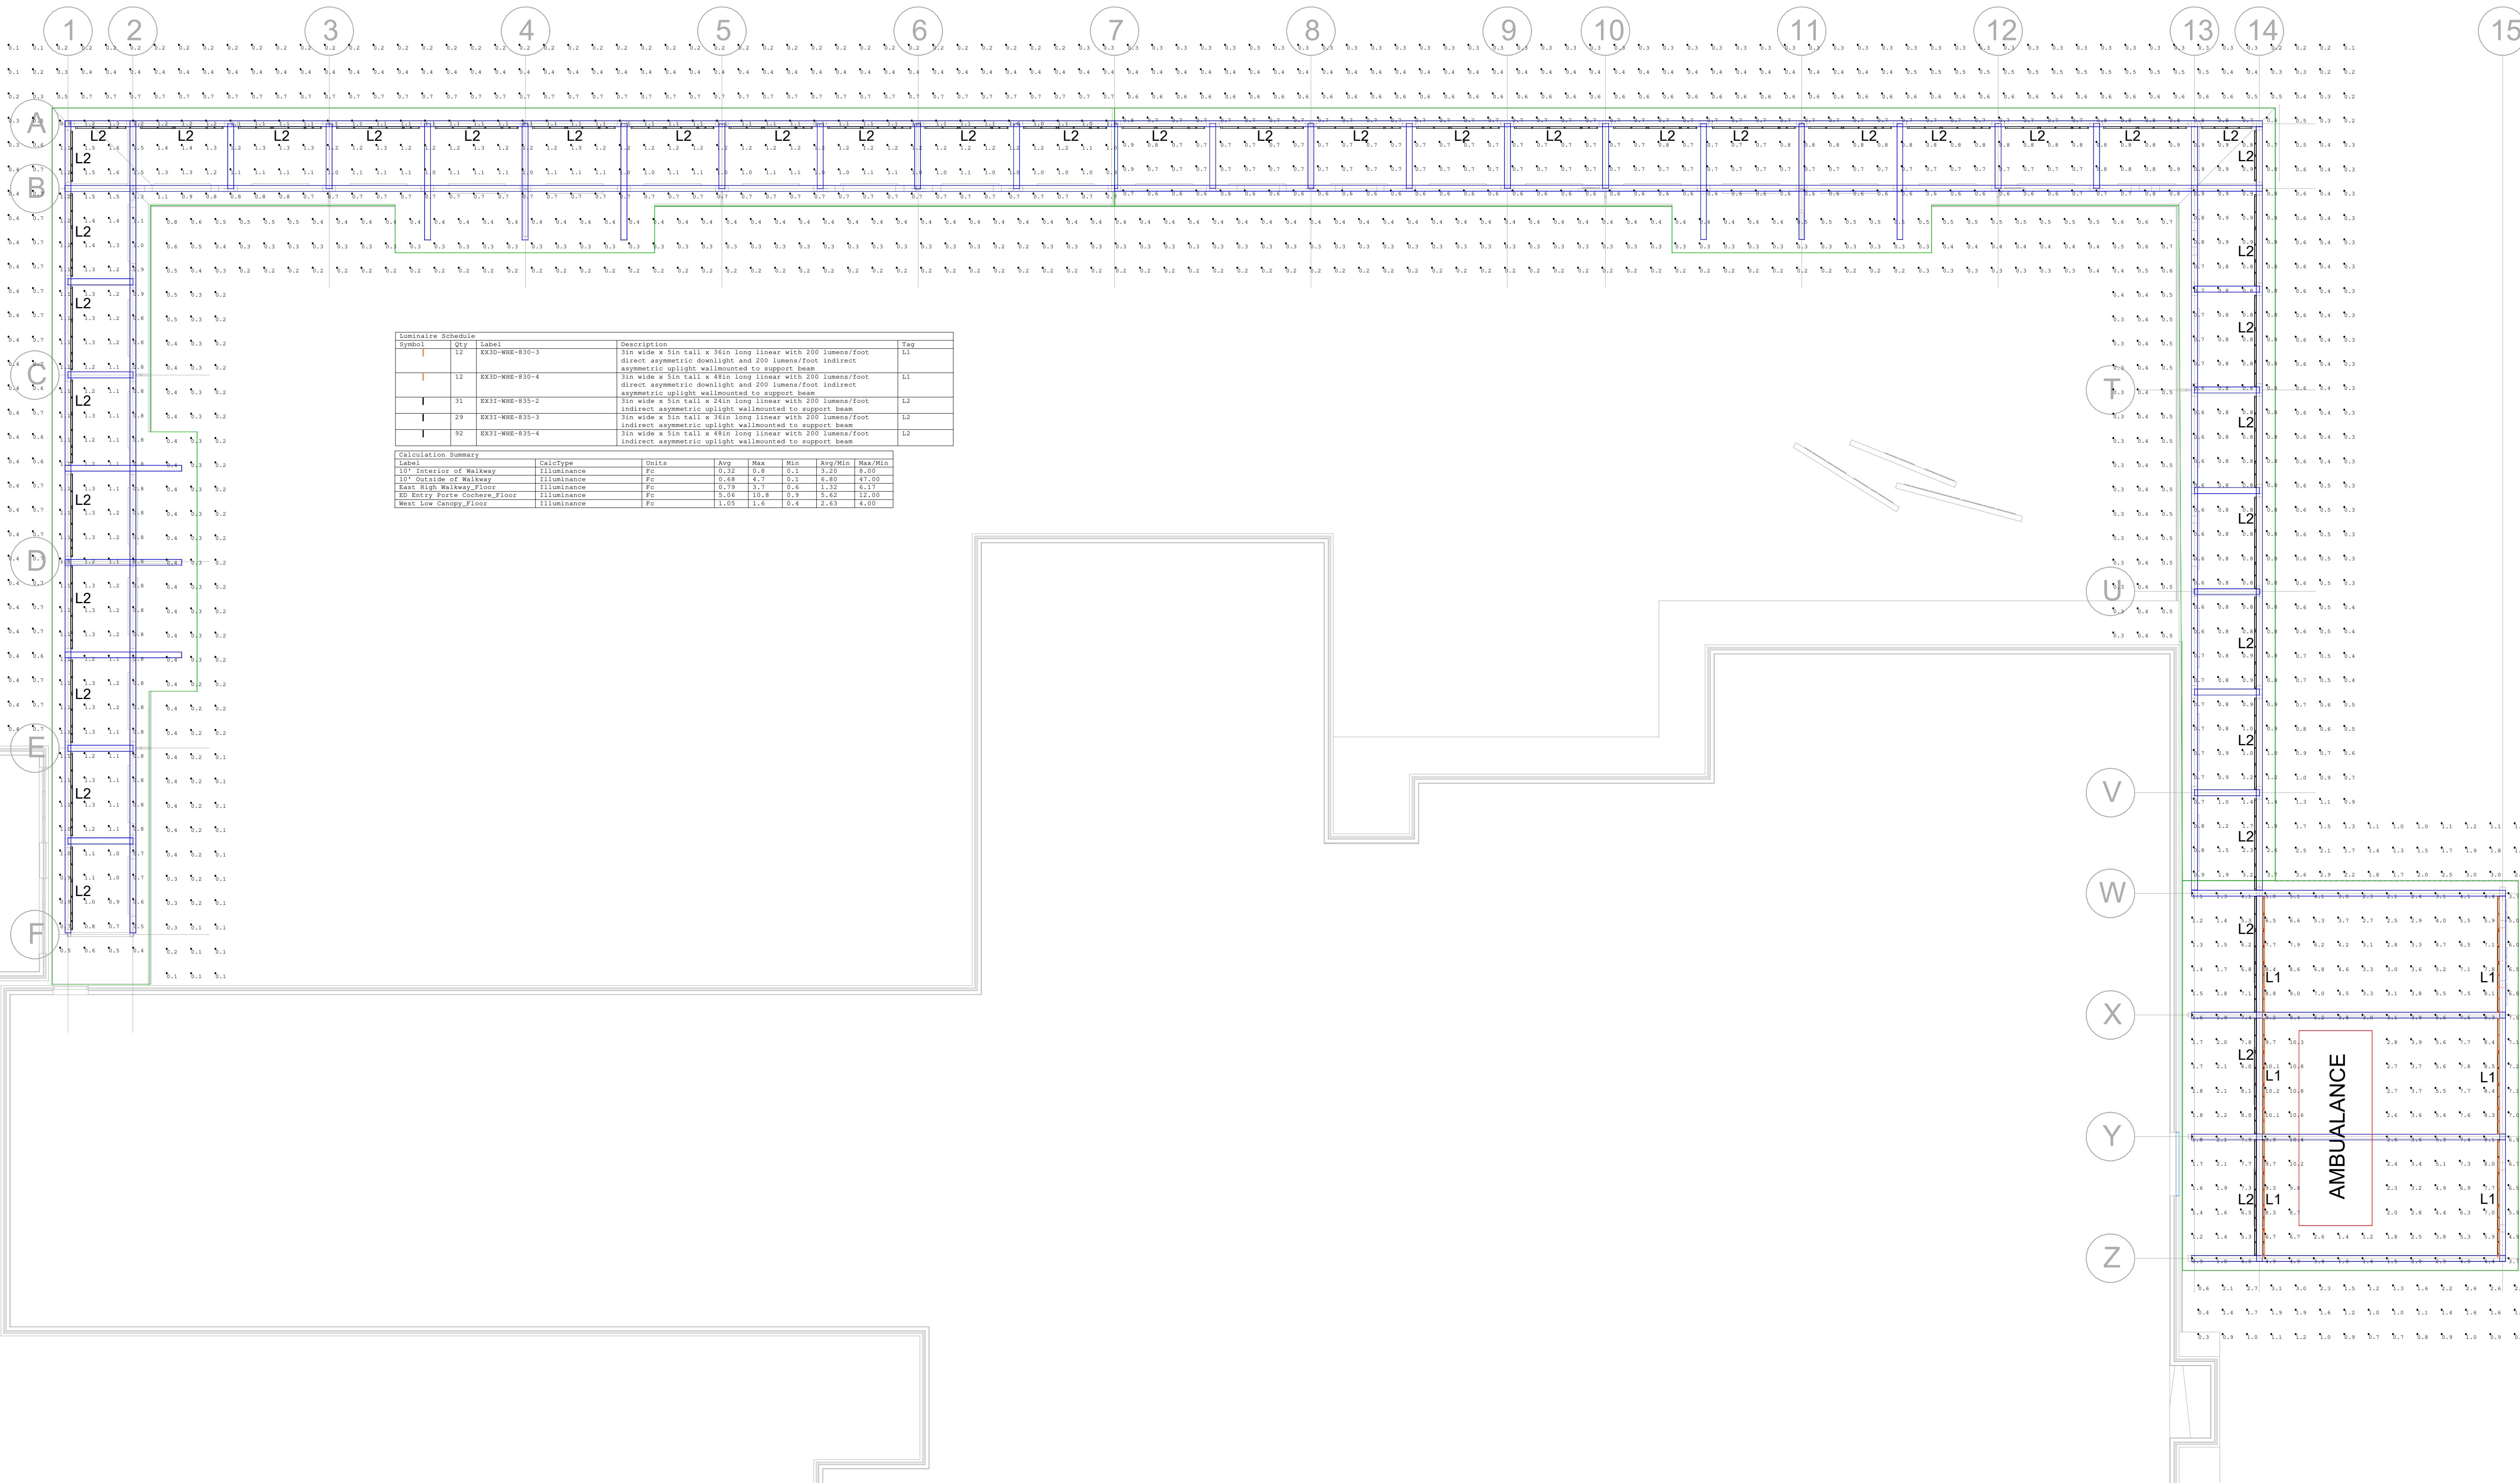


FOR REFERENCE  
ONLYSANTIAM HOSPITAL AND  
CLINICS  
SANTIAM HOSPITAL  
EMERGENCY DEPARTMENT  
ENTRY  
1401 North 10th Ave.  
Stayton, OR 97383

## SITE PHOTOMETRICS CALCULATIONS

MARK	DATE	DESCRIPTION
ISSUE DATE:	23 MAY 2025	
ISSUE:		
PROJECT NO.:	2024802.00	
DRAWN BY:		
CHECKED BY:		
Copyright MAHLUM ARCHITECTS, INC.		ORIGINAL SHEET SIZE 30x42"

A PHOTOMETRIC LIGHTING PLAN

E-111

